

1 **SITE CONCEPT PLAN**
1/8" = 1'-0"


**SITE PLAN IS DIAGRAMMATIC ONLY
REFER TO DRAWINGS PROVIDED
BY CROY ENGINEERING**

No.	Date	Issue Notes

THIS DRAWING IS THE PROPERTY OF E+E ARCHITECTURE & IS NOT TO BE REPRODUCED OR COPIED IN WHOLE OR IN PART WITHOUT WRITTEN APPROVAL. IT IS ONLY TO BE USED FOR THE PROJECT AND SITE SPECIFICALLY IDENTIFIED HEREIN AND IS NOT TO BE USED ON ANY OTHER SITE. IT IS TO BE RETURNED UPON REQUEST.

CONSULTING ENGINEERS:
MECHANICAL/PLUMBING:
 MK ENGINEERING, INC.
 181 SEDGEFIELD OVERLOOK
 DALLAS, GEORGIA 30157
 PHONE: (678) 642-7282
ELECTRICAL ENGINEER:
 WESTSIDE ENGINEERING, LLC.
 5525 INTERSTATE N PARKWAY
 ATLANTA, GA 30328
STRUCTURAL ENGINEER:
 PALMER ENGINEERING
 3581 HABERSHAM AT NORTHLAKE
 TUCKER, GEORGIA 30084
 PHONE: (770) 908-9908

WADE'S PLACE
 1061 CONCORD ROAD SE
 SMYRNA, GEORGIA

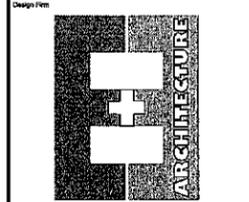

287 PRINCE AVENUE
 SUITE 288
 ATHENS, GA 30601
 PH: 706.850.1330

**ARCHITECTURAL
SITE PLAN**

Date: 5.15.15 Project #: 2015-35
 CAD File Name: AS-1.0

AS-1.0

No.	Date	Issue Notes

THIS DRAWING IS THE PROPERTY OF E+E ARCHITECTURE & IS NOT TO BE REPRODUCED OR COPIED IN WHOLE OR IN PART WITHOUT WRITTEN APPROVAL. IT IS ONLY TO BE USED FOR THE PROJECT AND SITE SPECIFICALLY IDENTIFIED HEREIN AND IS NOT TO BE USED ON ANY OTHER SITE. IT IS TO BE RETURNED UPON REQUEST.


CONSULTING ENGINEERS:
 MECHANICAL/PLUMBING:
 MK ENGINEERING, INC.
 181 SEDGEFIELD OVERLOOK
 DALLAS, GEORGIA 30157
 PHONE: (678) 642-7252
 ELECTRICAL ENGINEER:
 WESTSIDE ENGINEERING, LLC.
 5525 INTERSTATE N PARKWAY
 ATLANTA, GA 30328
 STRUCTURAL ENGINEER:
 PALMER ENGINEERING,
 3581 HABERSHAM AT NORTHLAKE
 TUCKER, GEORGIA 30084
 PHONE: (770) 908-9908

WADE'S PLACE
 1061 CONCORD ROAD SE
 SMYRNA, GEORGIA




EXTERIOR ELEVATIONS
 Date: 03.16.16 Project ID: 2015-35
 CAD File Name: 2015-35


A-2.0

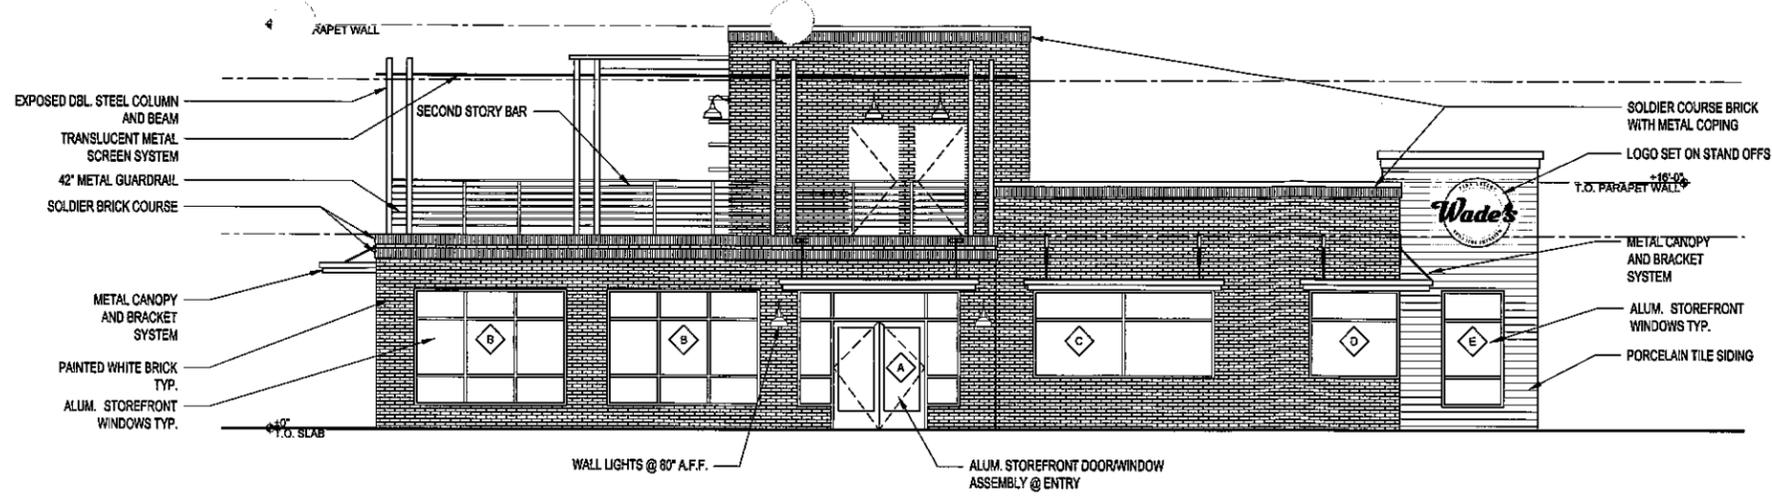


1 FRONT ELEVATION
 3/16" = 1'-0"

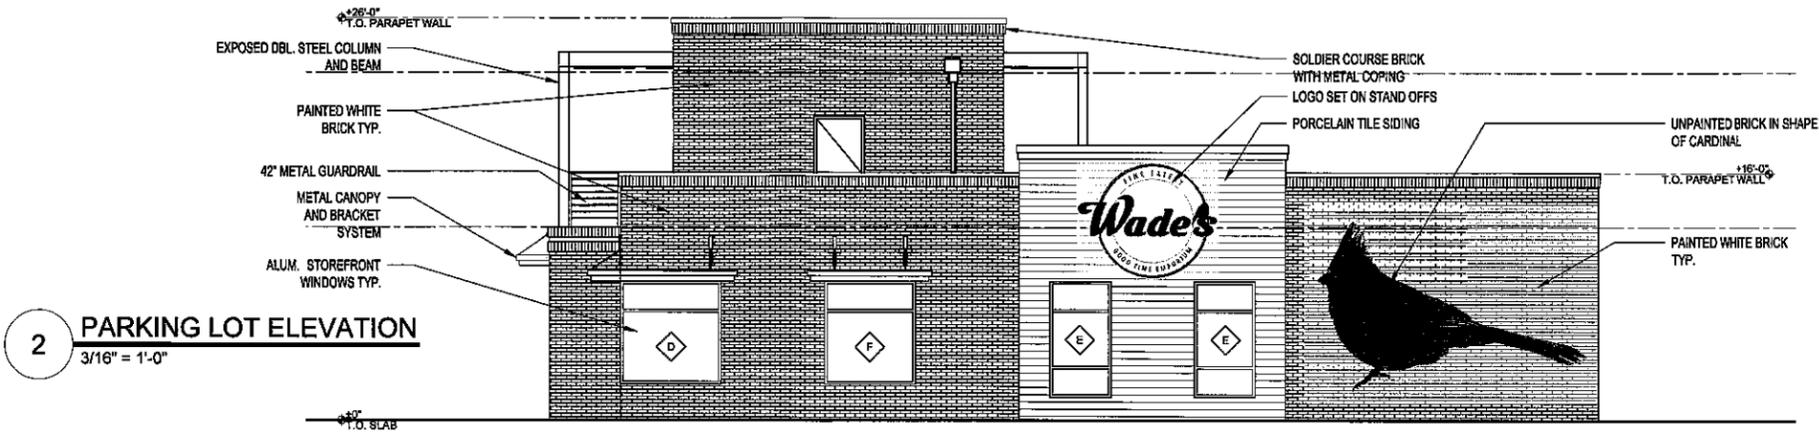


2 PARKING LOT ELEVATION
 3/16" = 1'-0"

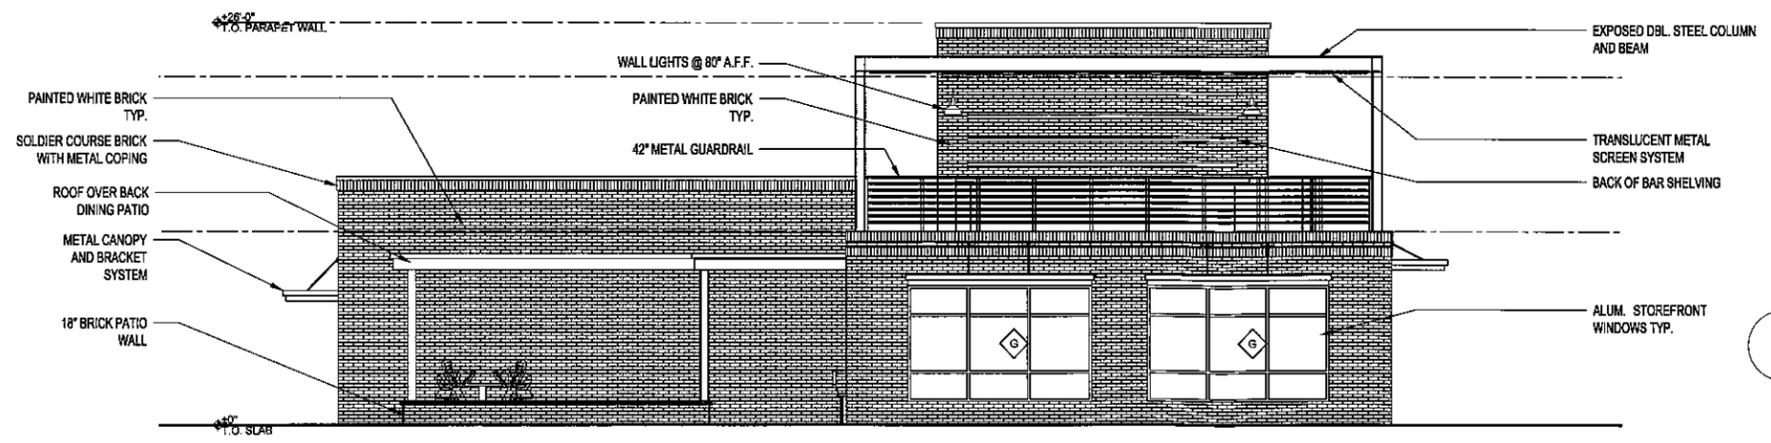


3 SIDE ELEVATION
 3/16" = 1'-0"

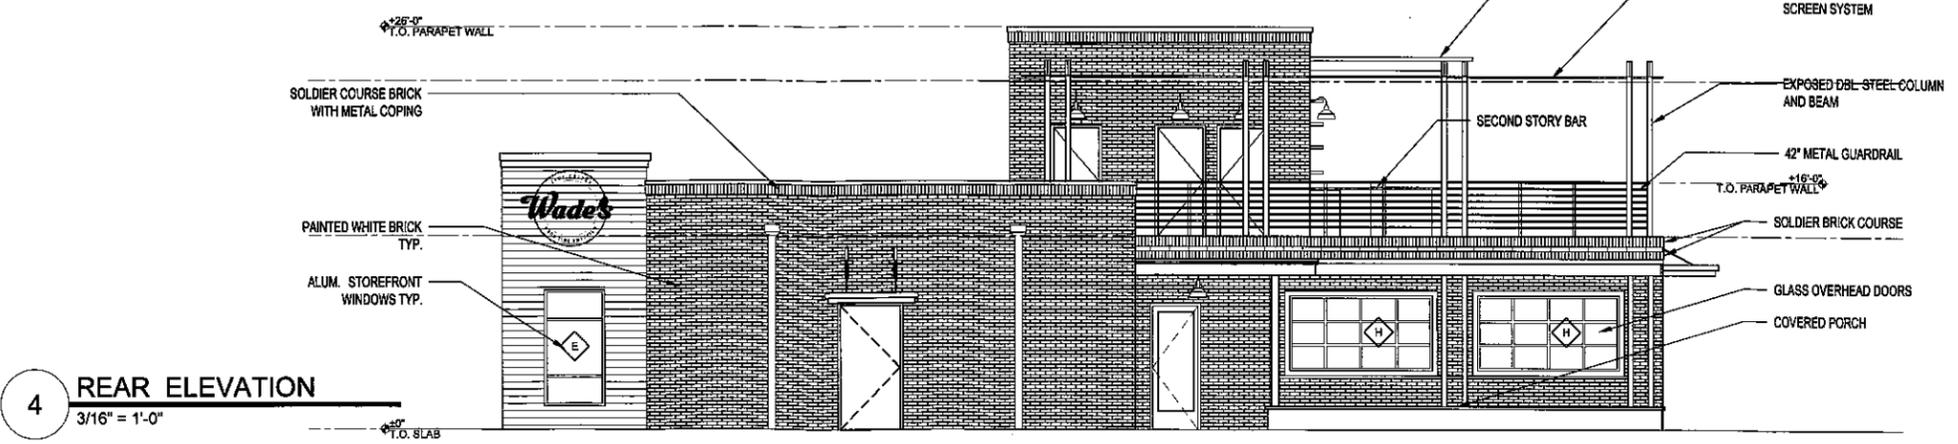

4 REAR ELEVATION
 3/16" = 1'-0"

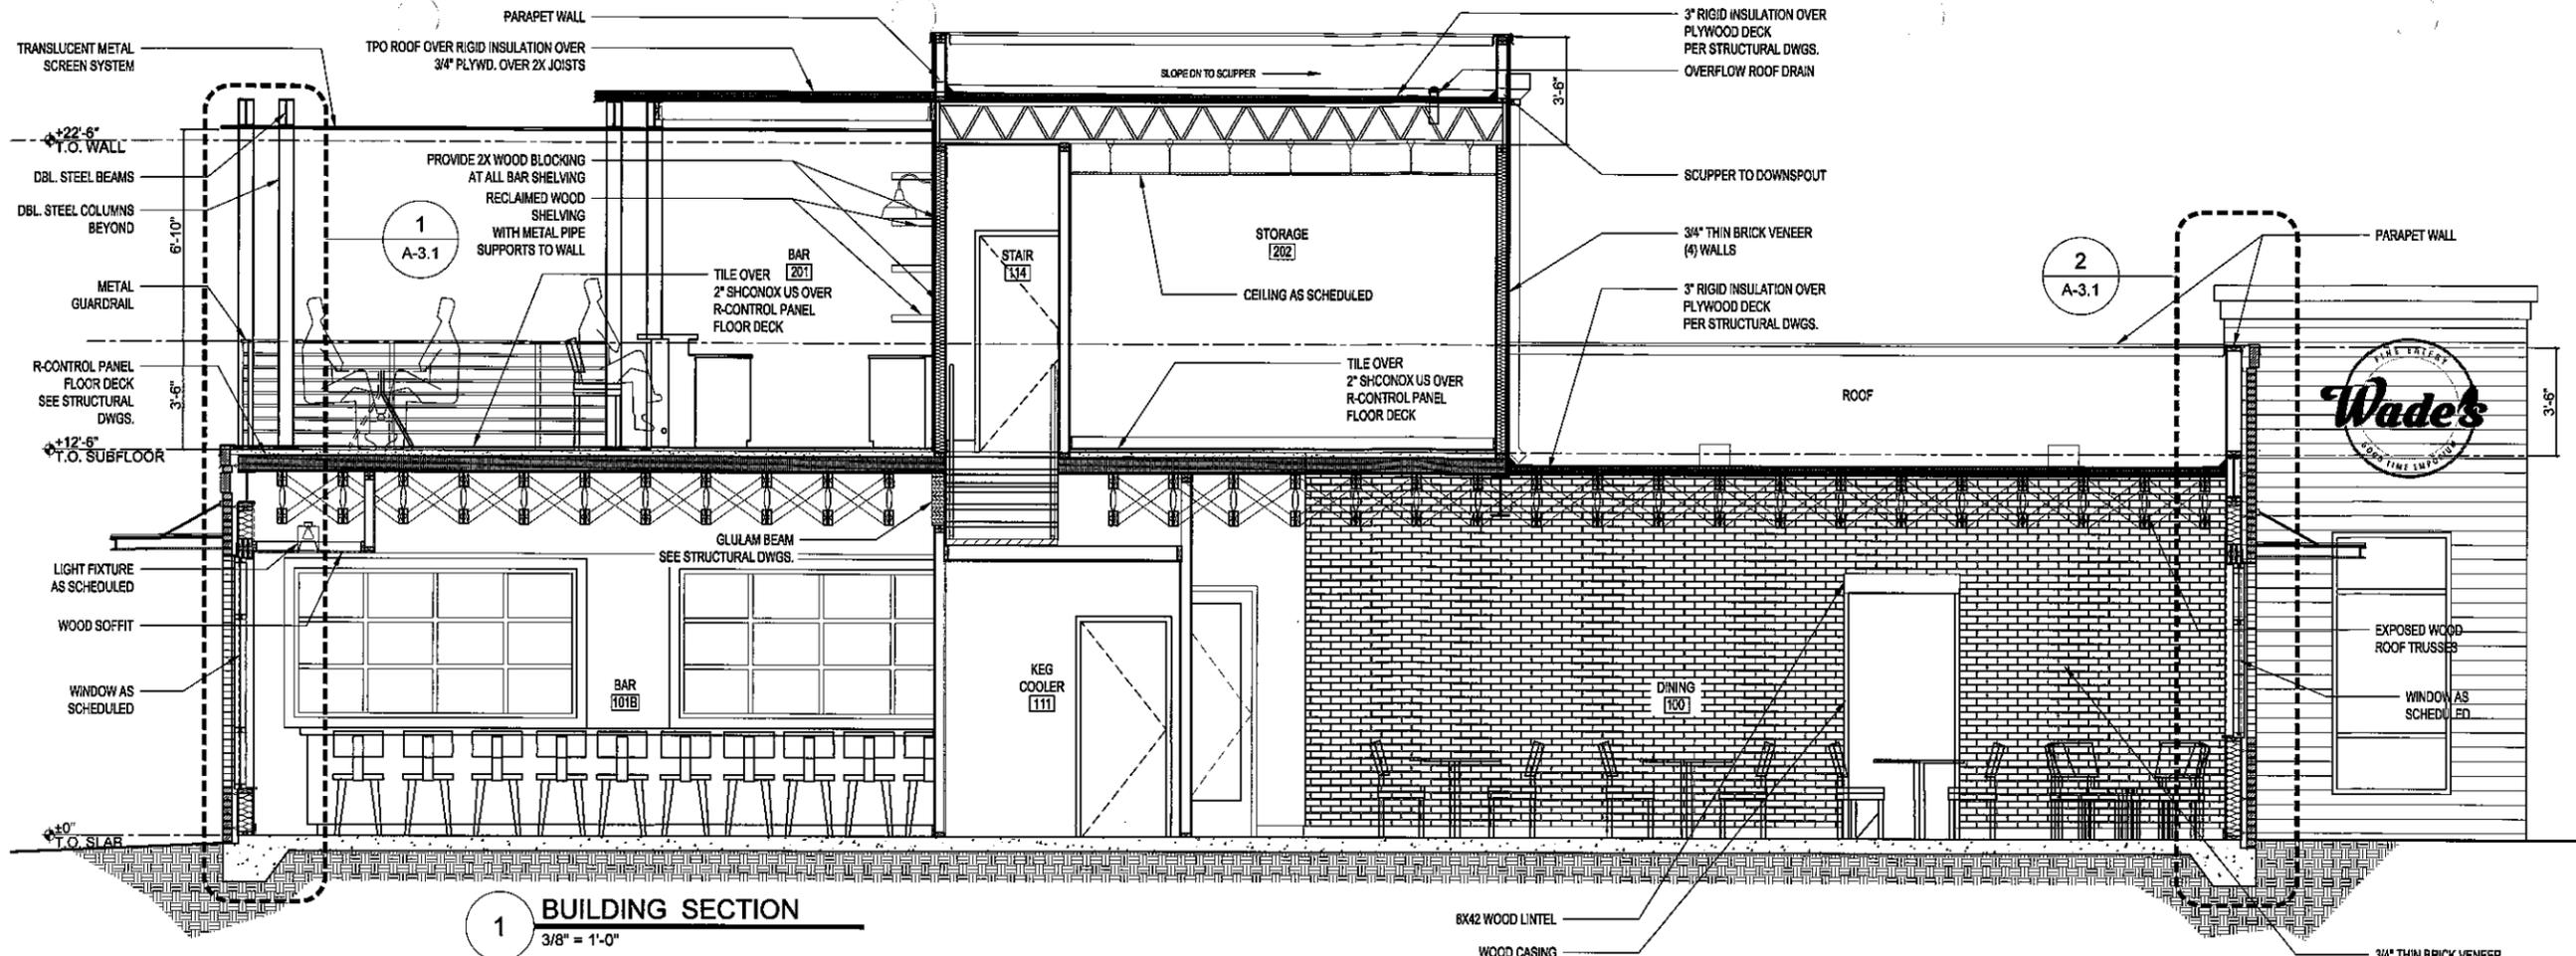

1 BUILDING SECTION
3/8" = 1'-0"

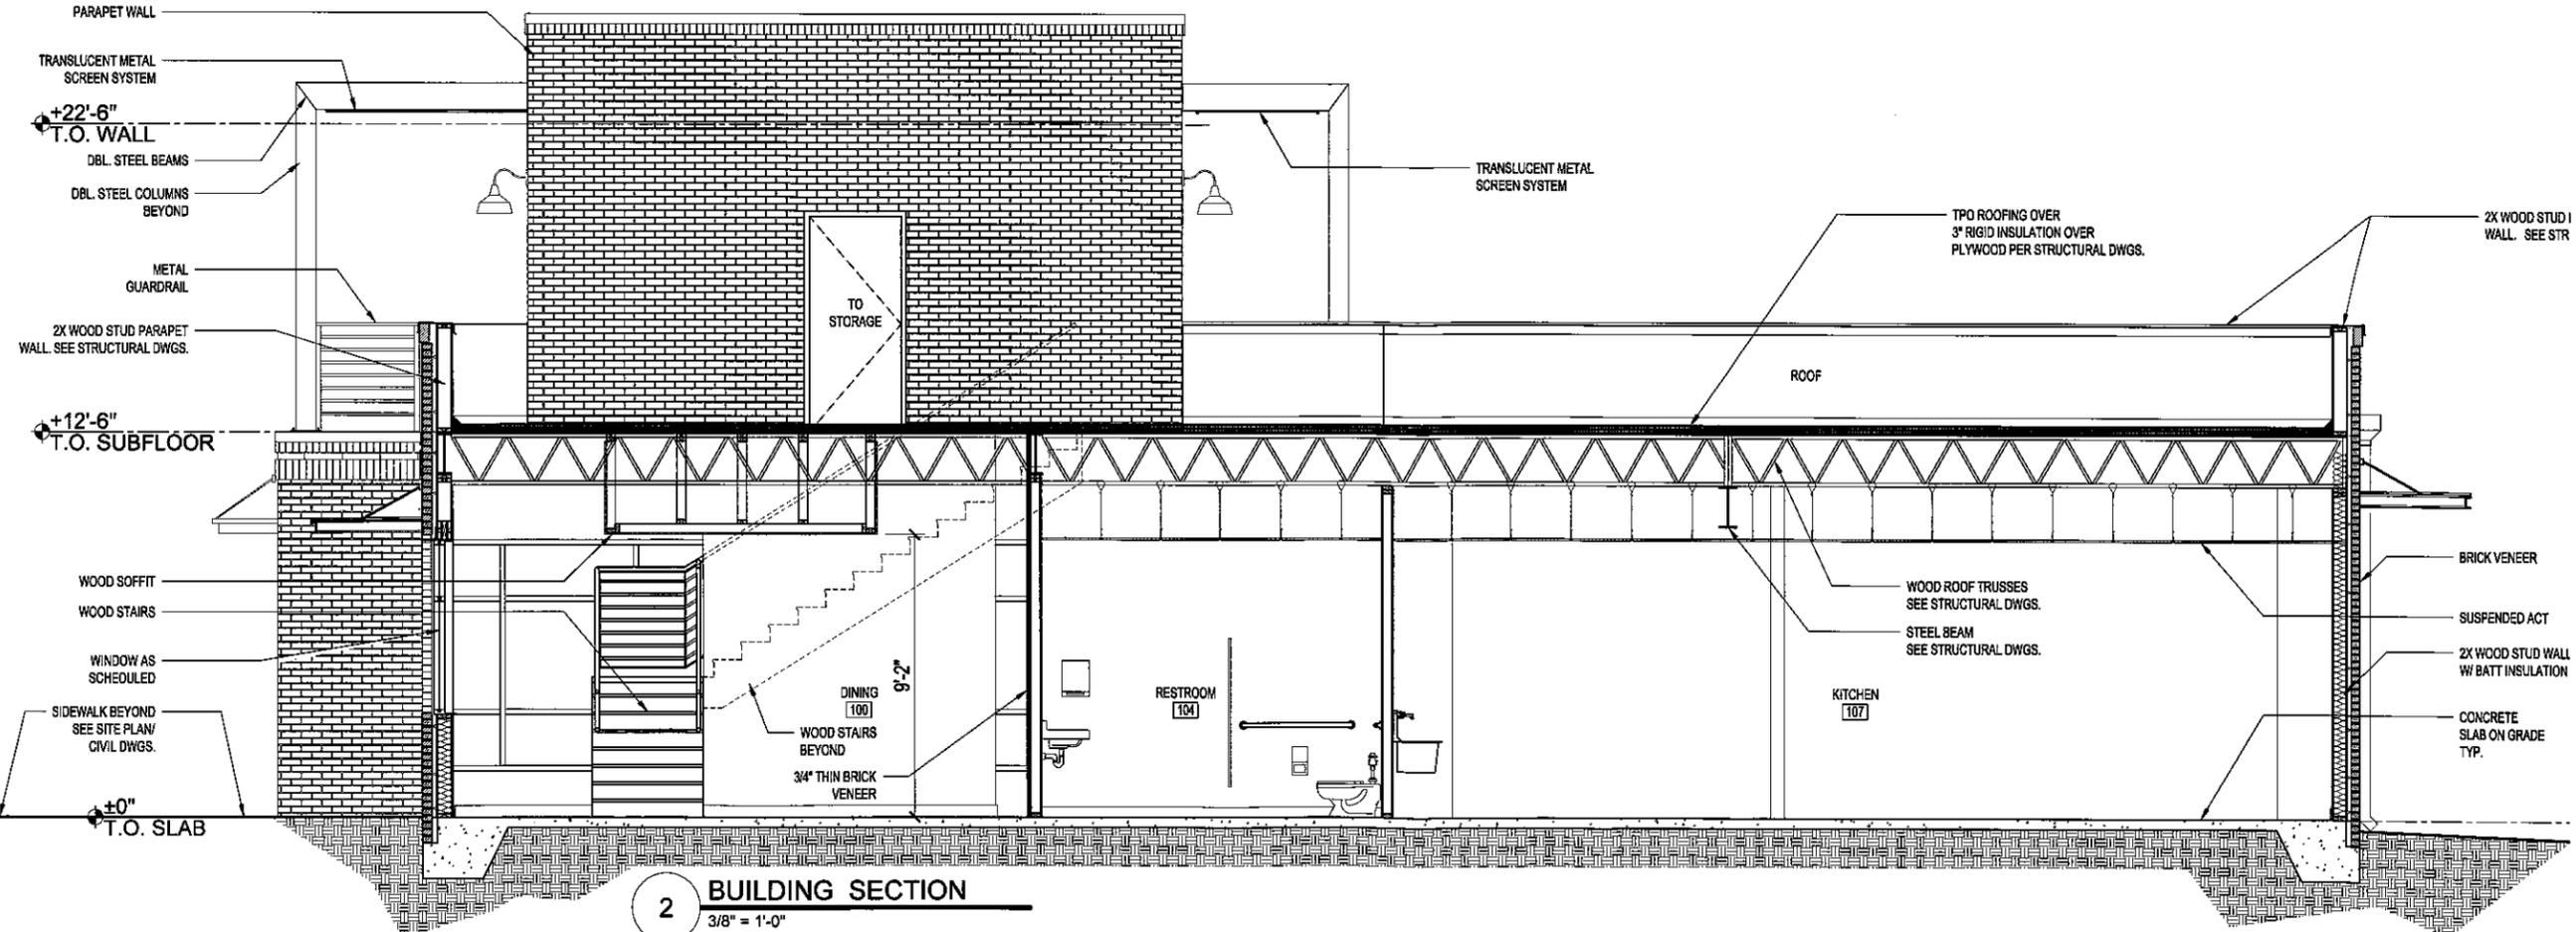

2 BUILDING SECTION
3/8" = 1'-0"

No. Date Issue Notes

THIS DRAWING IS THE PROPERTY OF E-E ARCHITECTURE & IS NOT TO BE REPRODUCED OR COPIED IN WHOLE OR IN PART WITHOUT WRITTEN APPROVAL. IT IS ONLY TO BE USED FOR THE PROJECT AND SITE SPECIFICALLY IDENTIFIED HEREIN AND IS NOT TO BE USED ON ANY OTHER SITE. IT IS TO BE RETURNED UPON REQUEST.

CONSULTING ENGINEERS:

MECHANICAL/PLUMBING:
MK ENGINEERING, INC.
181 SEDGEFIELD OVERLOOK
DALLAS, GEORGIA 30157
PHONE: (678) 642-7282

ELECTRICAL ENGINEER:
WESTSIDE ENGINEERING, LLC.
5525 INTERSTATE N PARKWAY
ATLANTA, GA 30328

STRUCTURAL ENGINEER:
PALMER ENGINEERING,
3681 HABERSHAM AT NORTH LAKE
TUCKER, GEORGIA 30084
PHONE: (770) 908-9908

WADE'S PLACE
1061 CONCORD ROAD SE
SMYRNA, GEORGIA



Building Sections

Date: 03.18.16 Project ID: 2015-35

CAD File Name: 2015-35

Drawing No. **A-3**