

FRAME & FLOOR	AXLES BRK (5) RECYCLED ON A & D (6) RECYCLED ON B & C	WALLS - WINDOWS - DOORS HEAD 8'-0" BOTTOM 2'-4"	EXTERIOR HARD/PANEL 8" O.C. GROOVES OVER HOUSE WRAP OVER 7/16" OSB	ROOF 45 MIL BLACK EPDM ROOF DRAIN W/ EXTERNAL DOWNSPOUTS	ELECTRICAL SINGLE ENTRANCE PANEL (4) 150 AMP LIGHTS (46) #1T 2 TUBE RECESSED FLUORESCENT T-8	A/C & HEAT TYPE A/C (4) 3TON WALL MT. BARD PROGRAMMABLE THERMOSTATS (4)	RESTROOMS STANDARD (2) H/C TANK TYPE HANDICAP 2 1/2
HITCH REMOVABLE XXXX STANDARD	STUDS 2"x4"x91 5/8" @ 16" O.C. #2 SIP	INSULATION R- ONE HOUR FIRE WALLS PER PLAN EXTERIOR: 13K INTERIOR: 11UF	SLIDING COLOR	STYLE TRANSVERSE	LIGHTS (2) 12WATT FLUORESCENT PORCH LIGHT W/PHOTOCELL	W.H. LAV (2) W/CHROME WRIST BLADE FAUCET	
I-BEAM 2"x8"x161" @ 16" O.C. ON 13'-8"	COVERING 5/8" TYPE-X VINYL COVER GRP (COLOR) 4 MIL	INSULATION R- INTERIOR: 12"-20"	BOTTOM TRIM COLOR	CEILING JOIST: 2"x6" @ 16" O.C.	POWER (2) VENT FAN/LIGHT COMBO (4) V-2262	MIRROR (2)	
JOIST 2"x8"x161" @ 16" O.C. ON 13'-8"	CUT BACK: INTERIOR: 12"-20"	TOP TRIM COLOR	CEILING 5/8" GRP TOPCON*	SHIP LOOSE: 12"x6S BLACK ROOF CAP	WATER (2) 1/2" PVC	GRAB BAR (2) 36" (2) 42" @ 36" AFF	
INSUL R- 19 UF	CUT BACK: EXTERIOR: N/A	CUT BACK: EXTERIOR: N/A	INSULATION R- 38K	EXIT SIGNS (2) W/BATTERY BACK UP (1) CEILING MT DIRECTIONAL EXIT SIGN	EMERGENCY LIGHTS (2) STD EMERGENCY LIGHTS	URINAL N/A	
DECKING DRG. 5/8" 18G PLYWOOD	COVERING 1/8" (COLOR) BLOCK TILE IN BATHS ONLY	SKIRTING: T.B.D	TIE DOWNS NO	EMERGENCY LIGHTS (2) STD EMERGENCY LIGHTS	(20) WALL MT. L-BOXES W/ 1/2" STUB THRU FLOOR	SHOWER N/A	
CUT BACK: Finish 17"	DECKING 11"	DECALS T.B.D	CUT BACK: T-Grid	(2) WALL MT. L-BOXES W/ 1/2" STUB THRU FLOOR	(2) V-2246 ATTIC VENT	WATER HEATER (1) 6 GAL.	
			CUT BACK: Gypsum	(2) 120V EXTERIOR WEATHERPROOF RECEPT	(2) V-2247 PASSIVE VENT	SUPPLY: PEK WITH CUT OFFS	
			CEILING BEAM @ MAINLINE	(2) 120V EXTERIOR WEATHERPROOF RECEPT	(2) V-2247 PASSIVE VENT	SPECIAL	

NOTE: ALL WALL DIMENSIONS ARE TO WALL FINISH AND NOT TO THE STUD!!!


NOTE: ALL HEIGHTS SPECIFIED ARE MEASURED TO THE BOTTOM OF THE OBJECT OR ITEM.

COLOR CHART

- WALLS
- WINDOWS
- DOORS
- ELECTRICAL
- WIRING
- HVAC / DUCT / DIFFUSERS
- DIMENSIONS
- TRUSS BAYS
- PLUMBING

SYMBOL LEGEND

- PANEL BOX
- DUPLEX RECEPT 120V
- HOSPITAL GRADE RECEPT W/ 1-500V BLDG WIRE
- EXT. WEATHERPROOF 120V REC.
- DEDICATED RECEPT
- VENT FAN
- FLUORESCENT LIGHT
- EMERGENCY ORDER
- EMERGENCY ORDER
- DIRECTIONAL EXIT SIGN
- SINGLE SWITCH
- WALL MOUNTED RECEPT W/ BATTERY PACK
- 3XS EMERGENCY LAMP
- 3XS EMERGENCY LAMP
- 3XS EMERGENCY LAMP
- 24"x24" RETURN AIR GRILLE (CEILING)
- 24"x24" SUPPLY AIR DIFFUSER (CEILING)
- 24"x24" RETURN AIR GRILLE (CEILING)
- 24"x24" SUPPLY AIR DIFFUSER (CEILING)
- 15"x15" RETURN AIR GRILLE (CEILING)
- 6"x10" SUPPLY AIR DIFFUSER (CEILING)

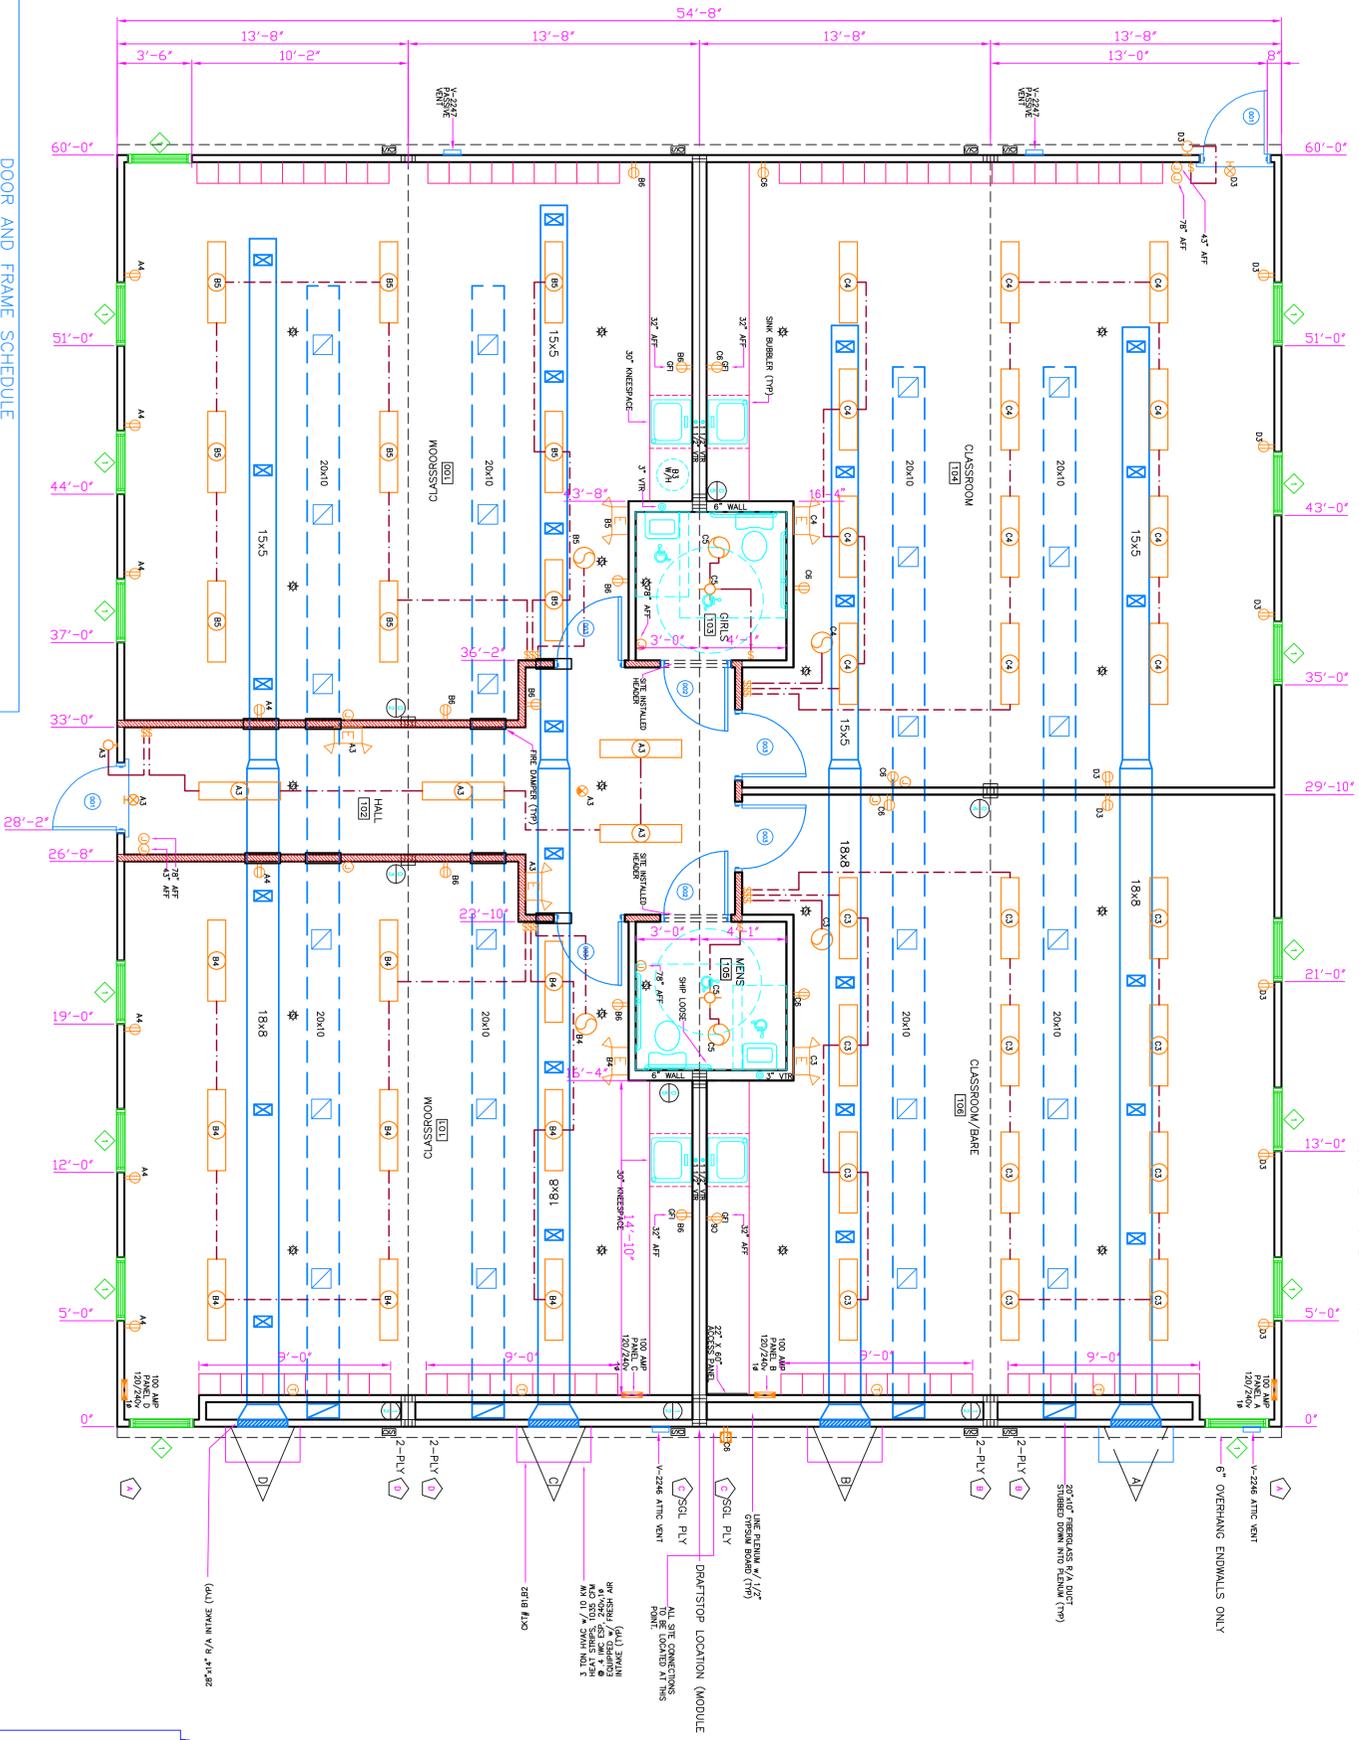

DOOR AND FRAME SCHEDULE

Quantity	MARK	WD	HGT	GLAZING	HWD	TYPE	FRAME	STYLE	FIRE RATING	NOTES
2	001	3'-0"	6'-8"	2X3X0	W/KNIGHT	18-R-PANIC W/ EXT. PULL	STEEL	N/A	N/A	CLOSER
2	002	3'-0"	6'-8"	N/A	BEST PRIVACY LEVER	STEEL	INTERNAL OAK 5/2"	20-MIN	N/A	CLOSER
4	003	3'-0"	6'-8"	18X30 WMC GLASS	BEST PRIVACY LEVER	STEEL	INTERNAL OAK 5/2"	20-MIN	N/A	CLOSER

WINDOW SCHEDULE

Quantity	MARK	WD	HGT	STYLE	Sill Height	FRAME/GLASS	NOTES
19	1	3'-0"	5'-0"	Single Hung	1'-3"	1/2 S BRZ/LOW E INSULATED DRYS W/ 1" ALUM MAIN BLINDS	

IF THIS PRINT REQUIRES REVIEW AND/OR APPROVAL BY A THIRD PARTY AGENCY, ARCHITECT, ENGINEER, GOVERNMENT AGENCY, OR ANY COMBINATION OF THE ABOVE, ADD A MINIMUM OF THREE WEEKS TO THE NORMAL DELIVERY TIME.

REGARDLESS OF ANY PROMISED DELIVERY DATES, WRITTEN OR VERBAL, WE WILL NOT PURCHASE MATERIALS, SCHEDULE FOR PRODUCTION OR OTHERWISE BE COMMITTED UNTIL:

- 1) YOUR COMPANY'S WRITTEN PURCHASE ORDER
- 2) A SIGNED COPY OF THESE PRINTS AND
- 3) APPROVALS REFERRED TO IN THE ABOVE PARAGRAPH (IF REQUIRED) ARE IN THE OFFICE OF THE BUILDING MANUFACTURER.

THESE PRINTS AND SPECIFICATIONS ARE:

APPROVED AS IS _____ DATE: _____

APPROVED EXCEPT AS NOTED _____

REVISE AS NOTED AND RESUBMIT _____

BY: _____

No.	REVISION/ISSUE	Date

THIRD PARTY INSPECTION AGENCY
PROFESSIONAL SERVICE INDUSTRIES
3348 33rd STREET
ORLAND FLORIDA 32839
PLAN REVIEWER: WILLIAM E. NEARY, III

Manufacturer:
KINGS CUSTOM BUILDERS, INC
1508 US HIGHWAY 19S
ELLAVILLE, GA 31806
PH: 229-937-2538
FX: 229-937-2150

Dealer:
MODULAR SOLUTIONS

Project:
WHITEFIELD ACADEMY
SMYRNA, GA

SERIAL # K031435443 A-D

SALES/PERSON	DATE	CODE	DRAWN BY	MODEL #	APPROVAL #
MATTHEW FULTON	MAR 24, 2014	06/951	CHRISTIE WHITE	56660	

Scale: 1/4" = 1'-0"

DATE: MAR 24, 2014

QUOTE #

FLOOR PLAN

Sheet: A3