



# PLAN 1457



## Floor Plan

| REVISION DATE |
|---------------|
| 12-10-12      |
| 1-1-14        |

# PLAN 1457


DRAWING SCALE:  
1/8" = 1'-0"

SET NUMBER:  
09201


MODEL  
**PLAN 1457 "A"**

DRAWING TITLE  
EXTERIOR ELEVATIONS


SHEET NO.  
**A1.1A**

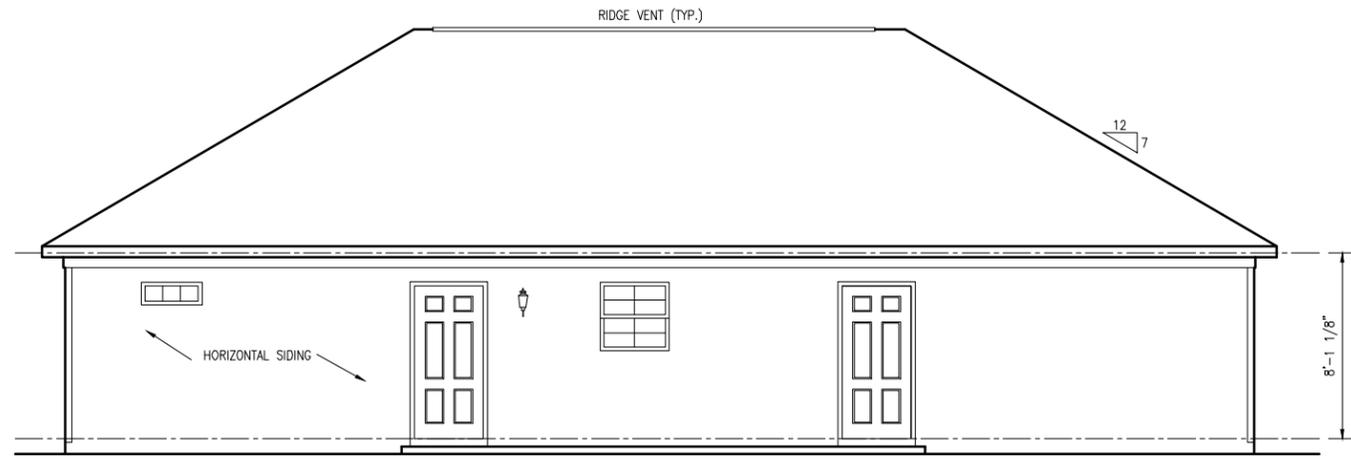


**REAR ELEVATION**

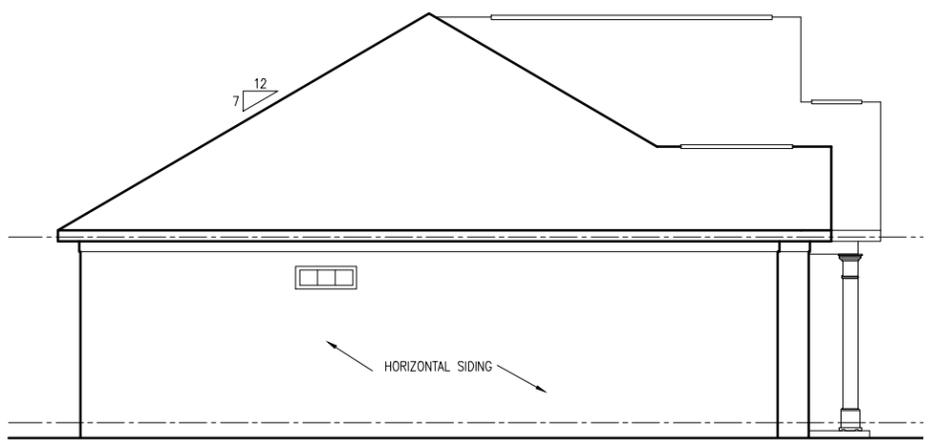


**LEFT ELEVATION**

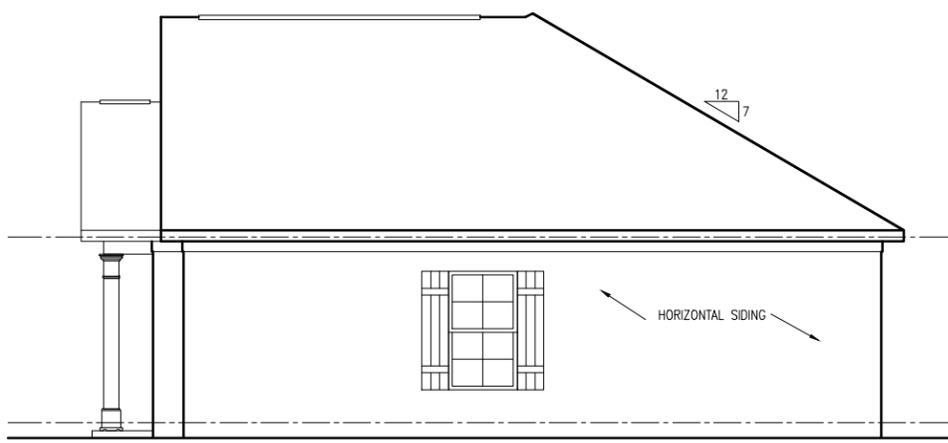

**RIGHT ELEVATION**

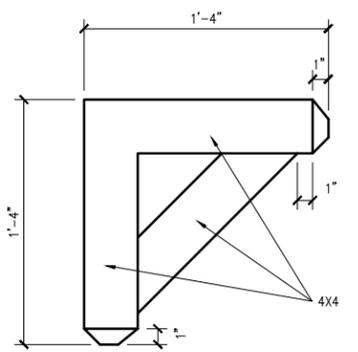


**GABLE LOOKOUT DETAIL**

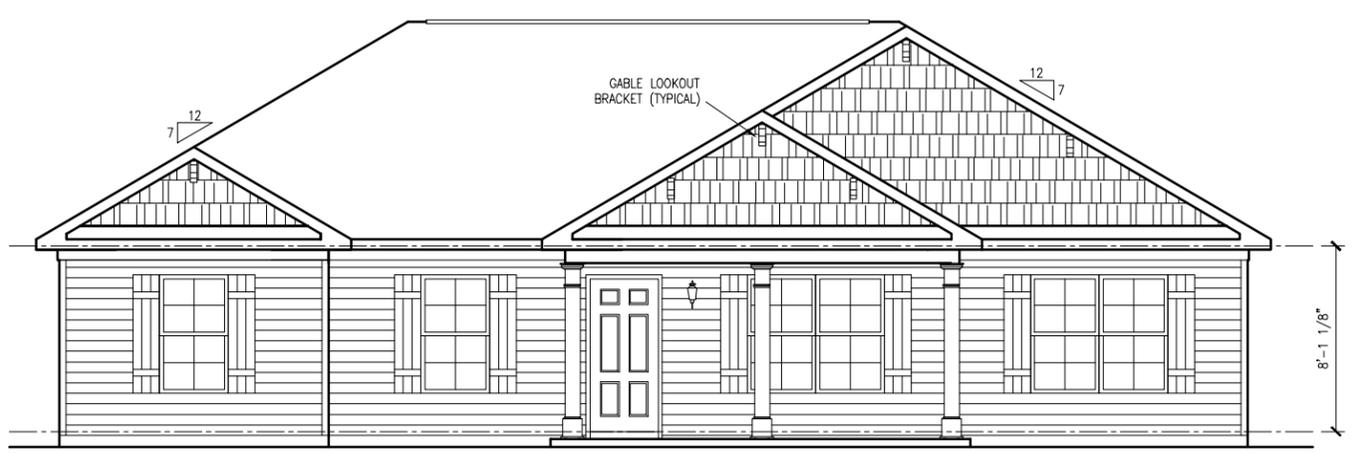

**FRONT ELEVATION**


| ELECTRICAL LEGEND |                        |   |                               |
|-------------------|------------------------|---|-------------------------------|
| ⊕                 | SWITCH                 | ⊕ | 110v RECEPTACLE               |
| ⊕3                | 3-WAY SWITCH           | ⊕ | 110v SWITCHED RECEPTACLE      |
| ⊕4                | 4-WAY SWITCH           | ⊕ | 110v ABOVE COUNTER RECEPTACLE |
| ⊕                 | WALL MOUNTED LIGHT     | ⊕ | GFI OUTLET                    |
| ⊕                 | CEILING FIXTURE OUTLET | ⊕ | 220v RECEPTACLE               |
| ⊕                 | BATH FAN/LIGHT COMBO   | ⊕ | CABLE OUTLET                  |
| ⊕                 | SMOKE DETECTOR         | ⊕ | PHONE                         |
|                   |                        | ⊕ | CHIMES                        |

NOTE: 1. INSTALL WASHER/DRYER OUTLETS AT 44" AFF  
2. INSTALL ALL KITCHEN COUNTERTOP OUTLETS AT 44" AFF  
3. INSTALL ALL BATH VANITY OUTLETS AT 42" AFF

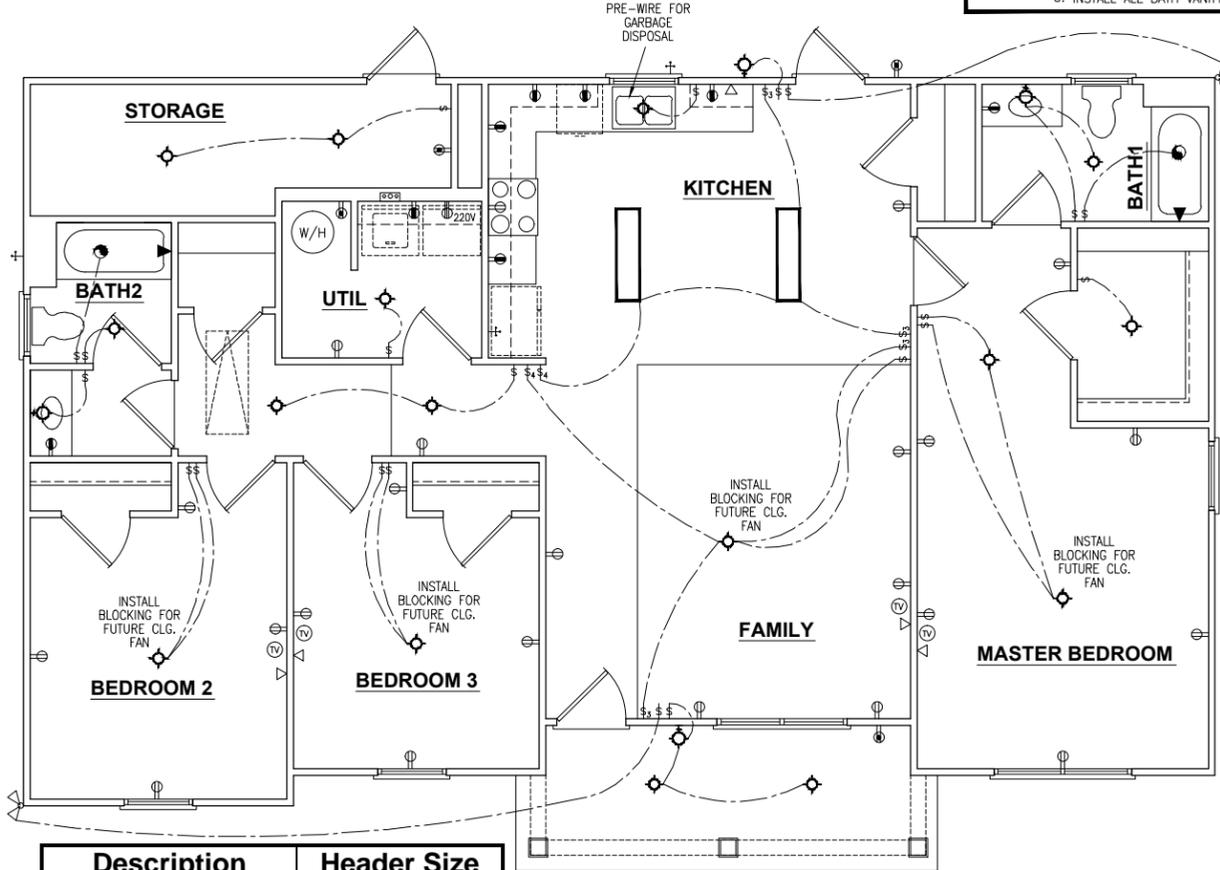

| Description                               | Header Size   |
|---|---------------|
| 2 <sup>8</sup> 1 <sup>0</sup> Window      | 35 3/4 inches |
| 3 <sup>0</sup> 5 <sup>2</sup> Window      | 39 3/4 inches |
| 3 <sup>0</sup> 3 <sup>0</sup> Window      | 39 3/4 inches |
| Twin 3 <sup>0</sup> 5 <sup>2</sup> Window | 78 1/4 inches |
| 3 <sup>0</sup> 6 <sup>8</sup> Door        | 41 inches     |

**ELECTRICAL PLAN**

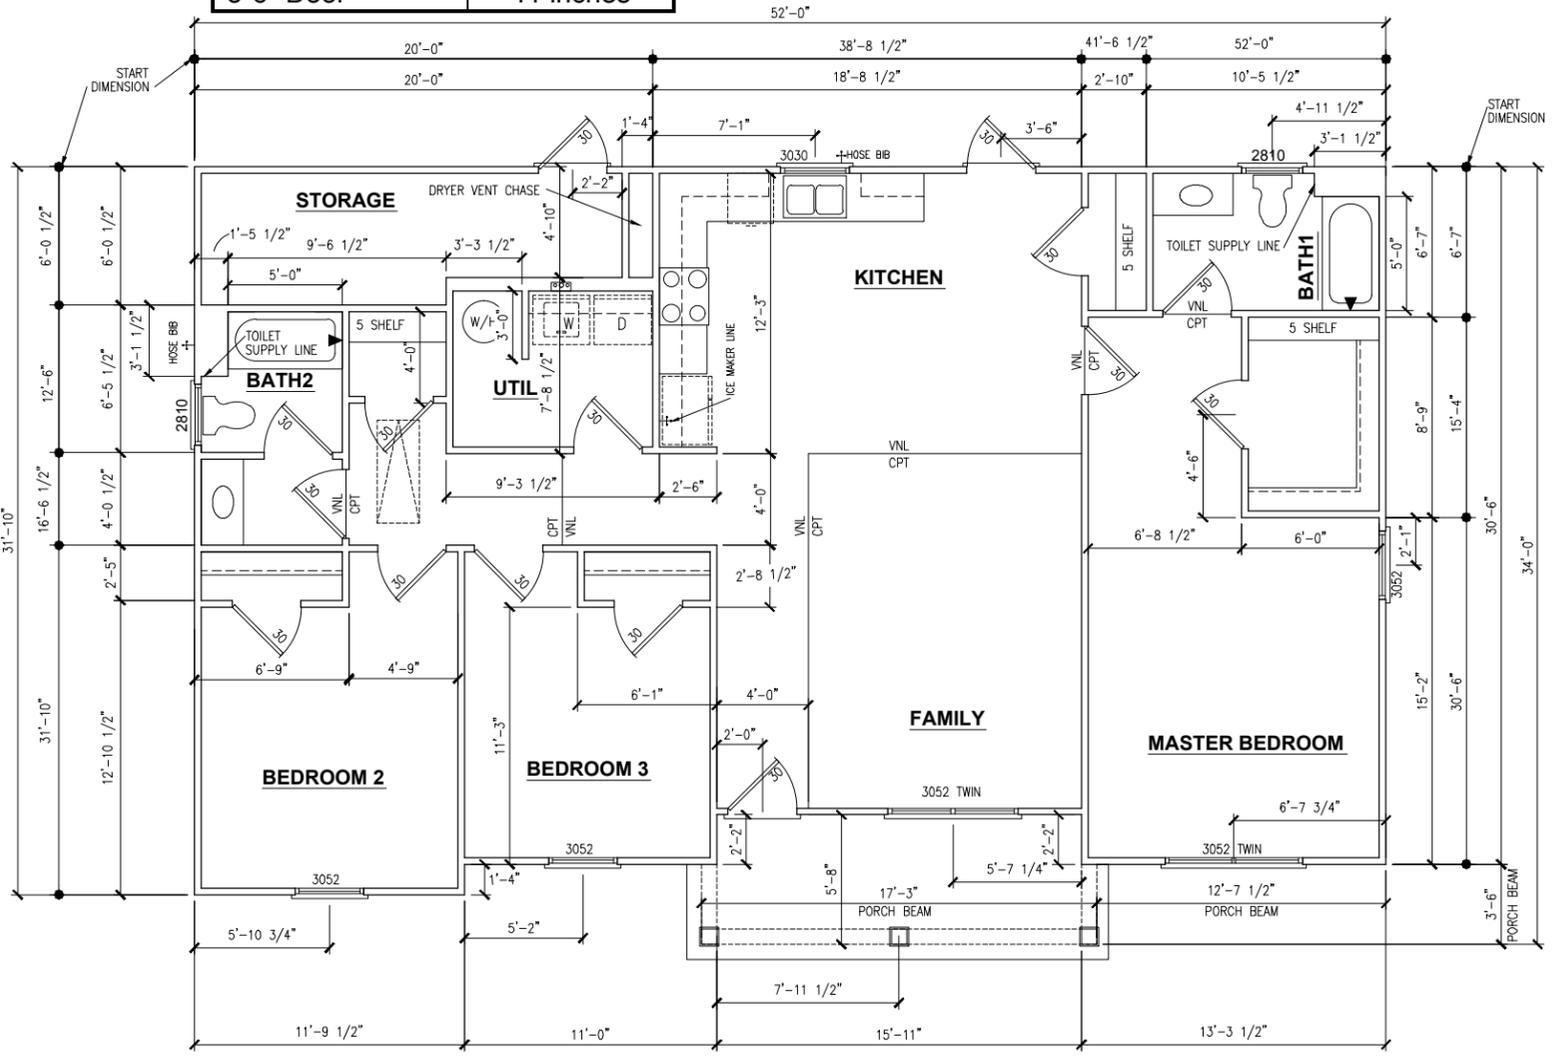

**FLOOR PLAN**

|                 |         |
|-----------------|---------|
| 1ST FLOOR AREA: | 1457 SF |
| STORAGE AREA:   | 110 SF  |
| PORCH AREA:     | 111 SF  |

|             |   |                  |                                |               |          |  |
|-------------|---|------------------|--------------------------------|---------------|----------|--|
| <b>A3.1</b> | MODEL<br><b>PLAN 1457</b>                     | <b>PLAN 1457</b> | DRAWING SCALE:<br>1/8" = 1'-0" | REVISION DATE | 12-10-12 |  |
|             | DRAWING TITLE<br>FLOOR PLAN & ELECTRICAL PLAN |                  |                                |               | 1-1-14   |  |
| SHEET NO.   | SET NUMBER:<br>09201                          |                  |                                |               |          |  |

Habitat for Humanity expressly reserves its property rights in these plans and drawings. These plans and related drawings are not to be reproduced without written consent from Habitat for Humanity.

